



PHANTOM SERIES


TRANSPARENT OUTDOOR RENTAL LED - TECHNICAL PACKAGE DRAWING

MODEL NUMBER

BLAV-PH-P391-3500X2000


P3.91 | 3.5 m x 2 m | REV E

DIMENSIONED FRONT ELEVATION

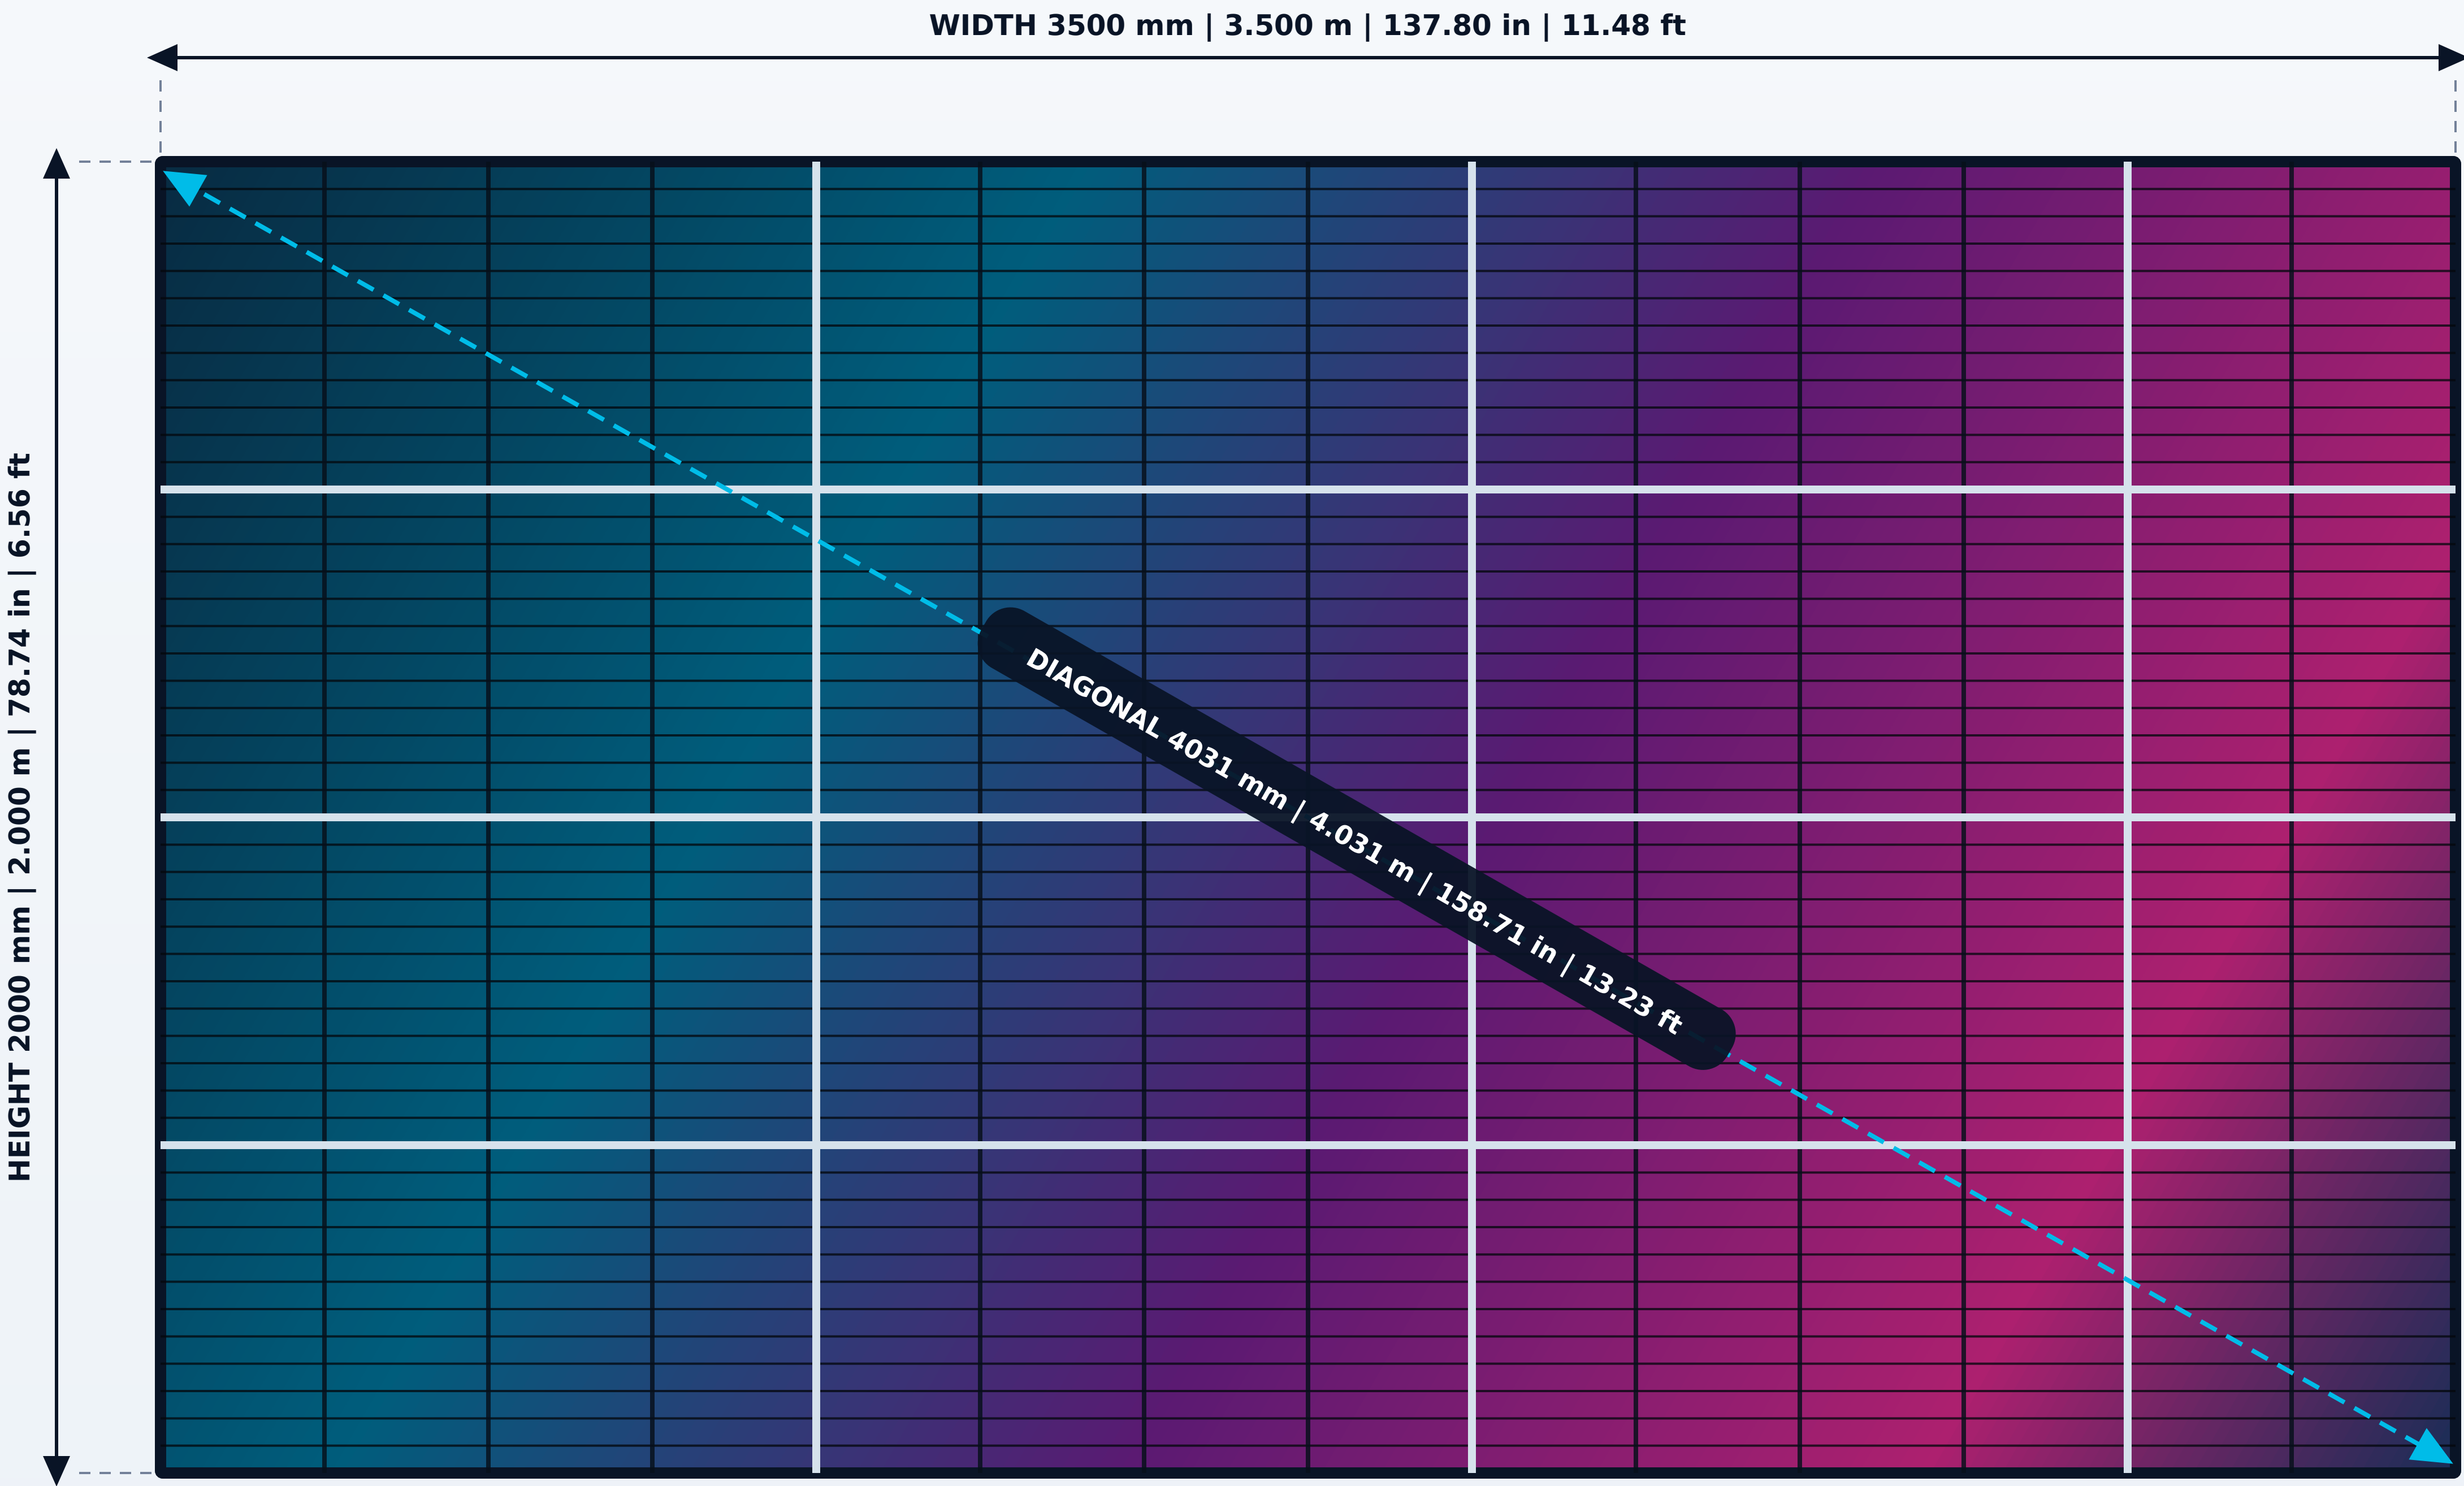


REAR ELEVATION

16 PHYSICAL CABINETS

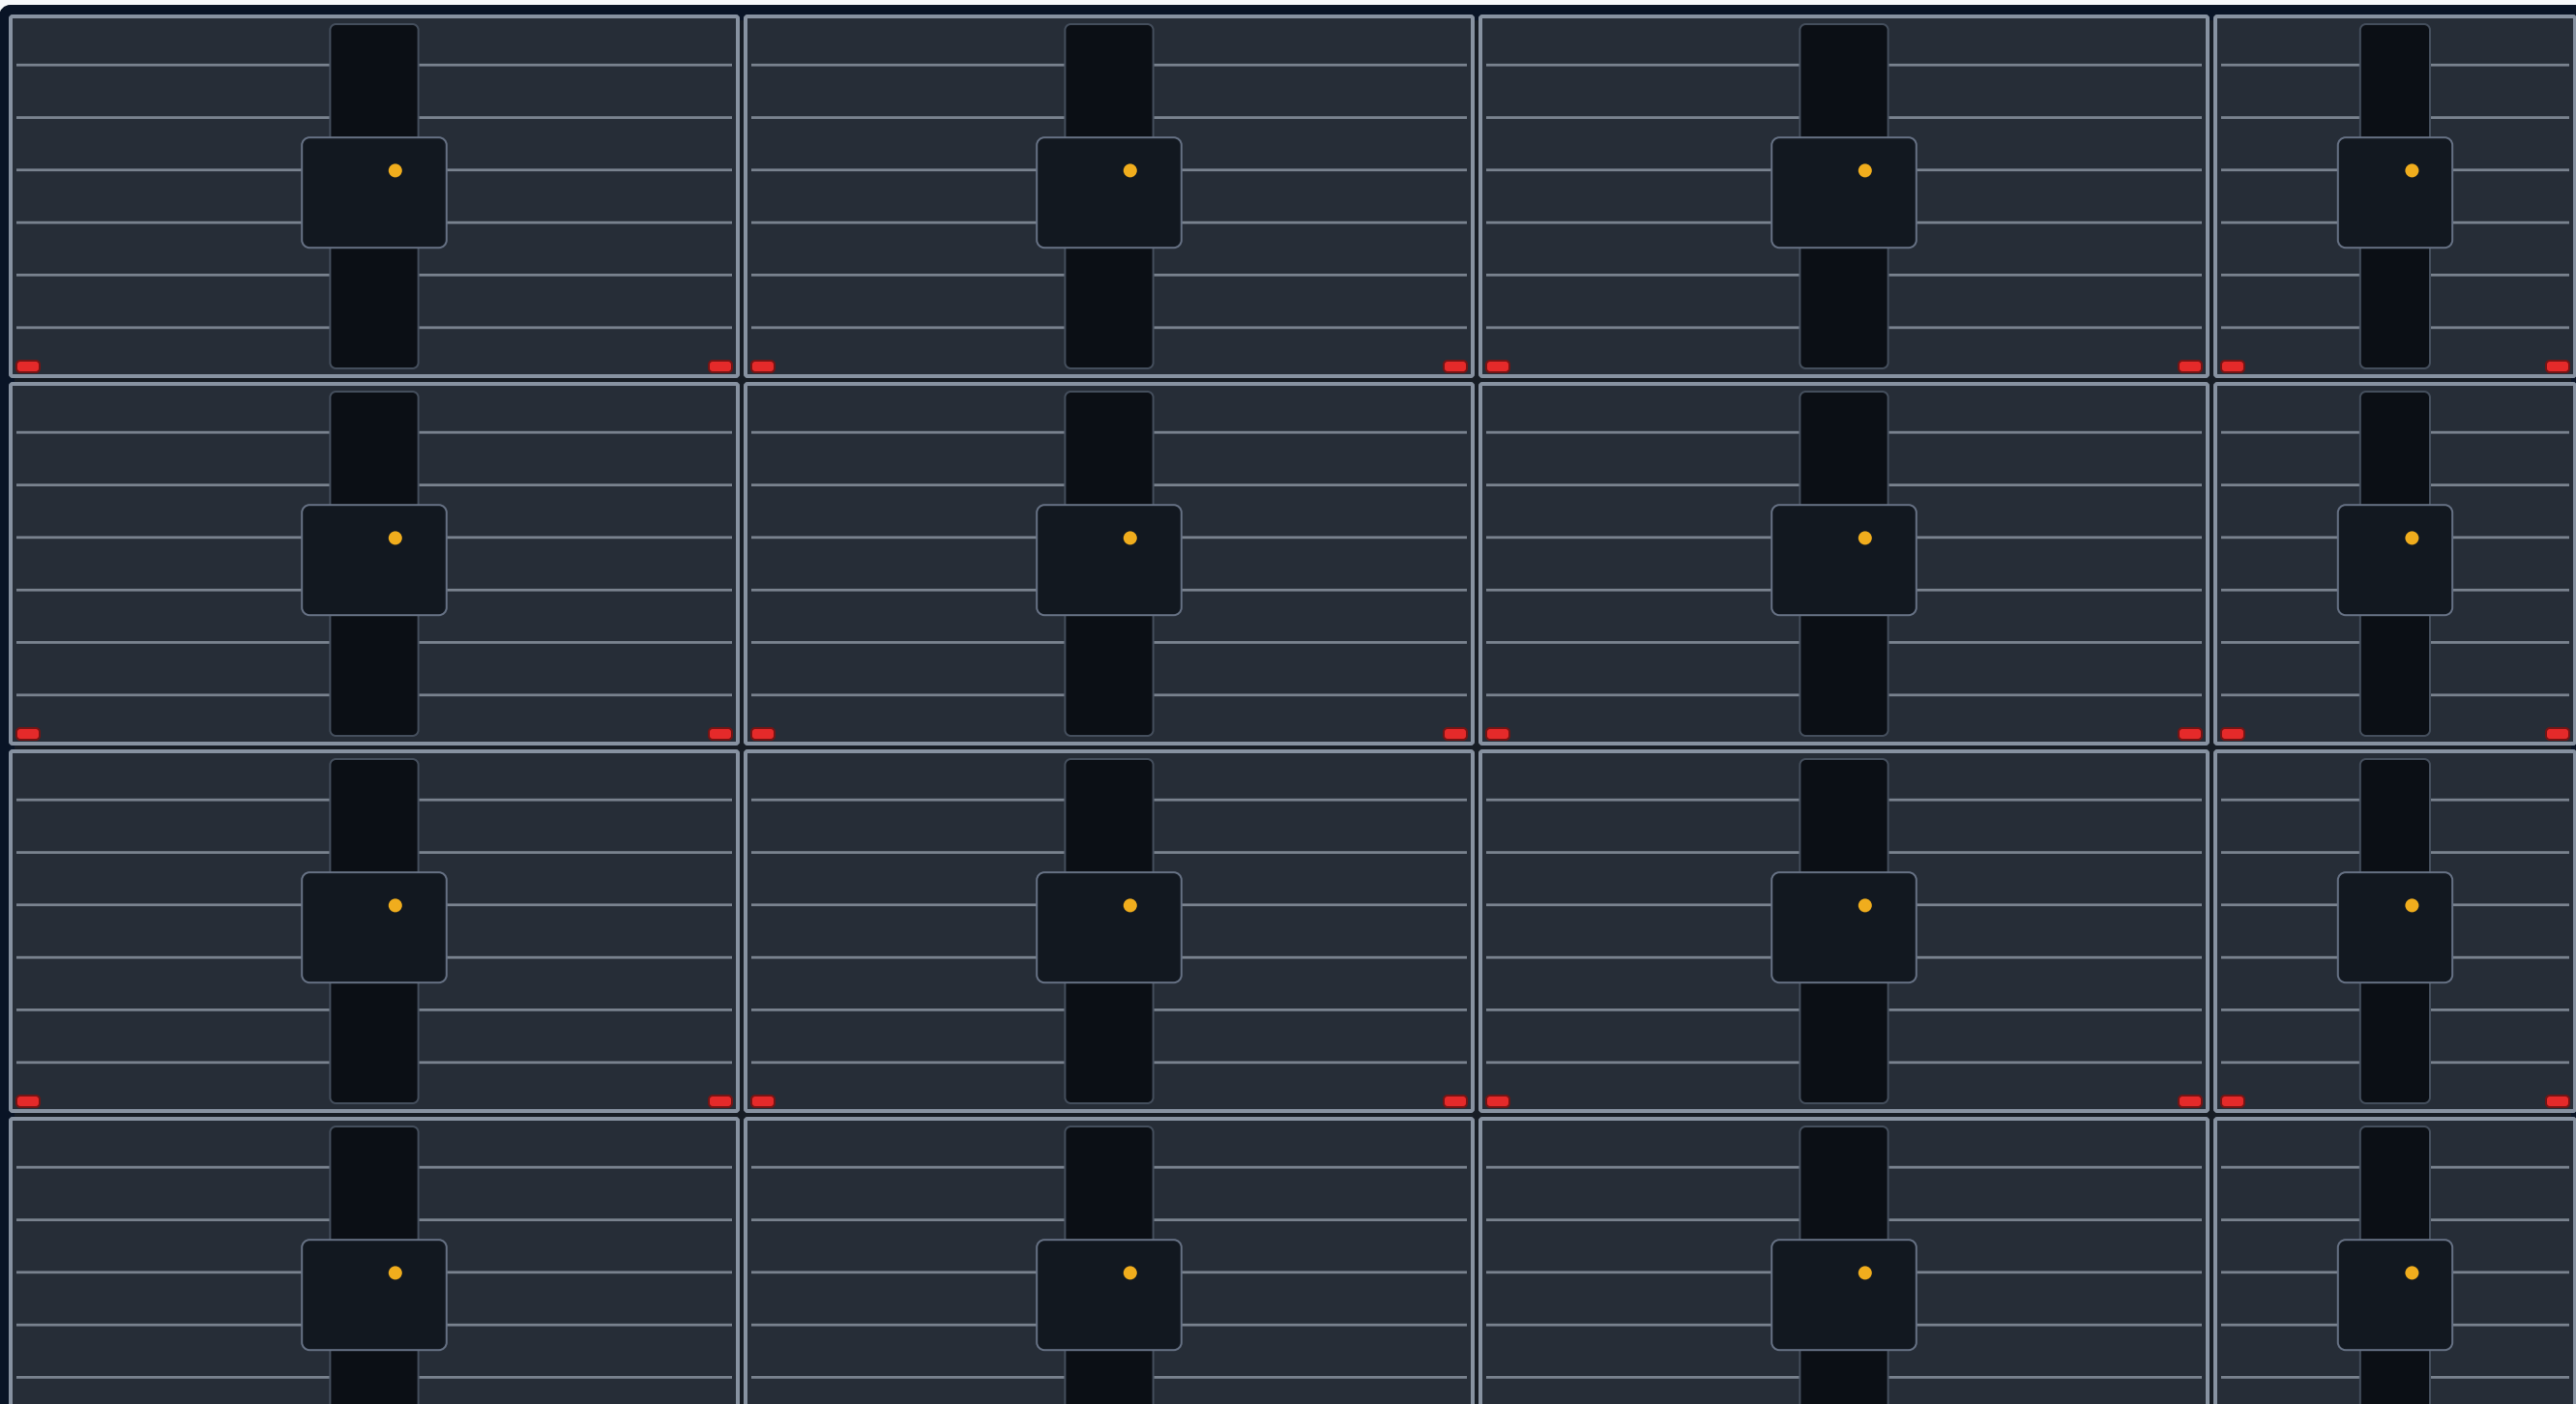

THREE-QUARTER ASSEMBLY VIEW

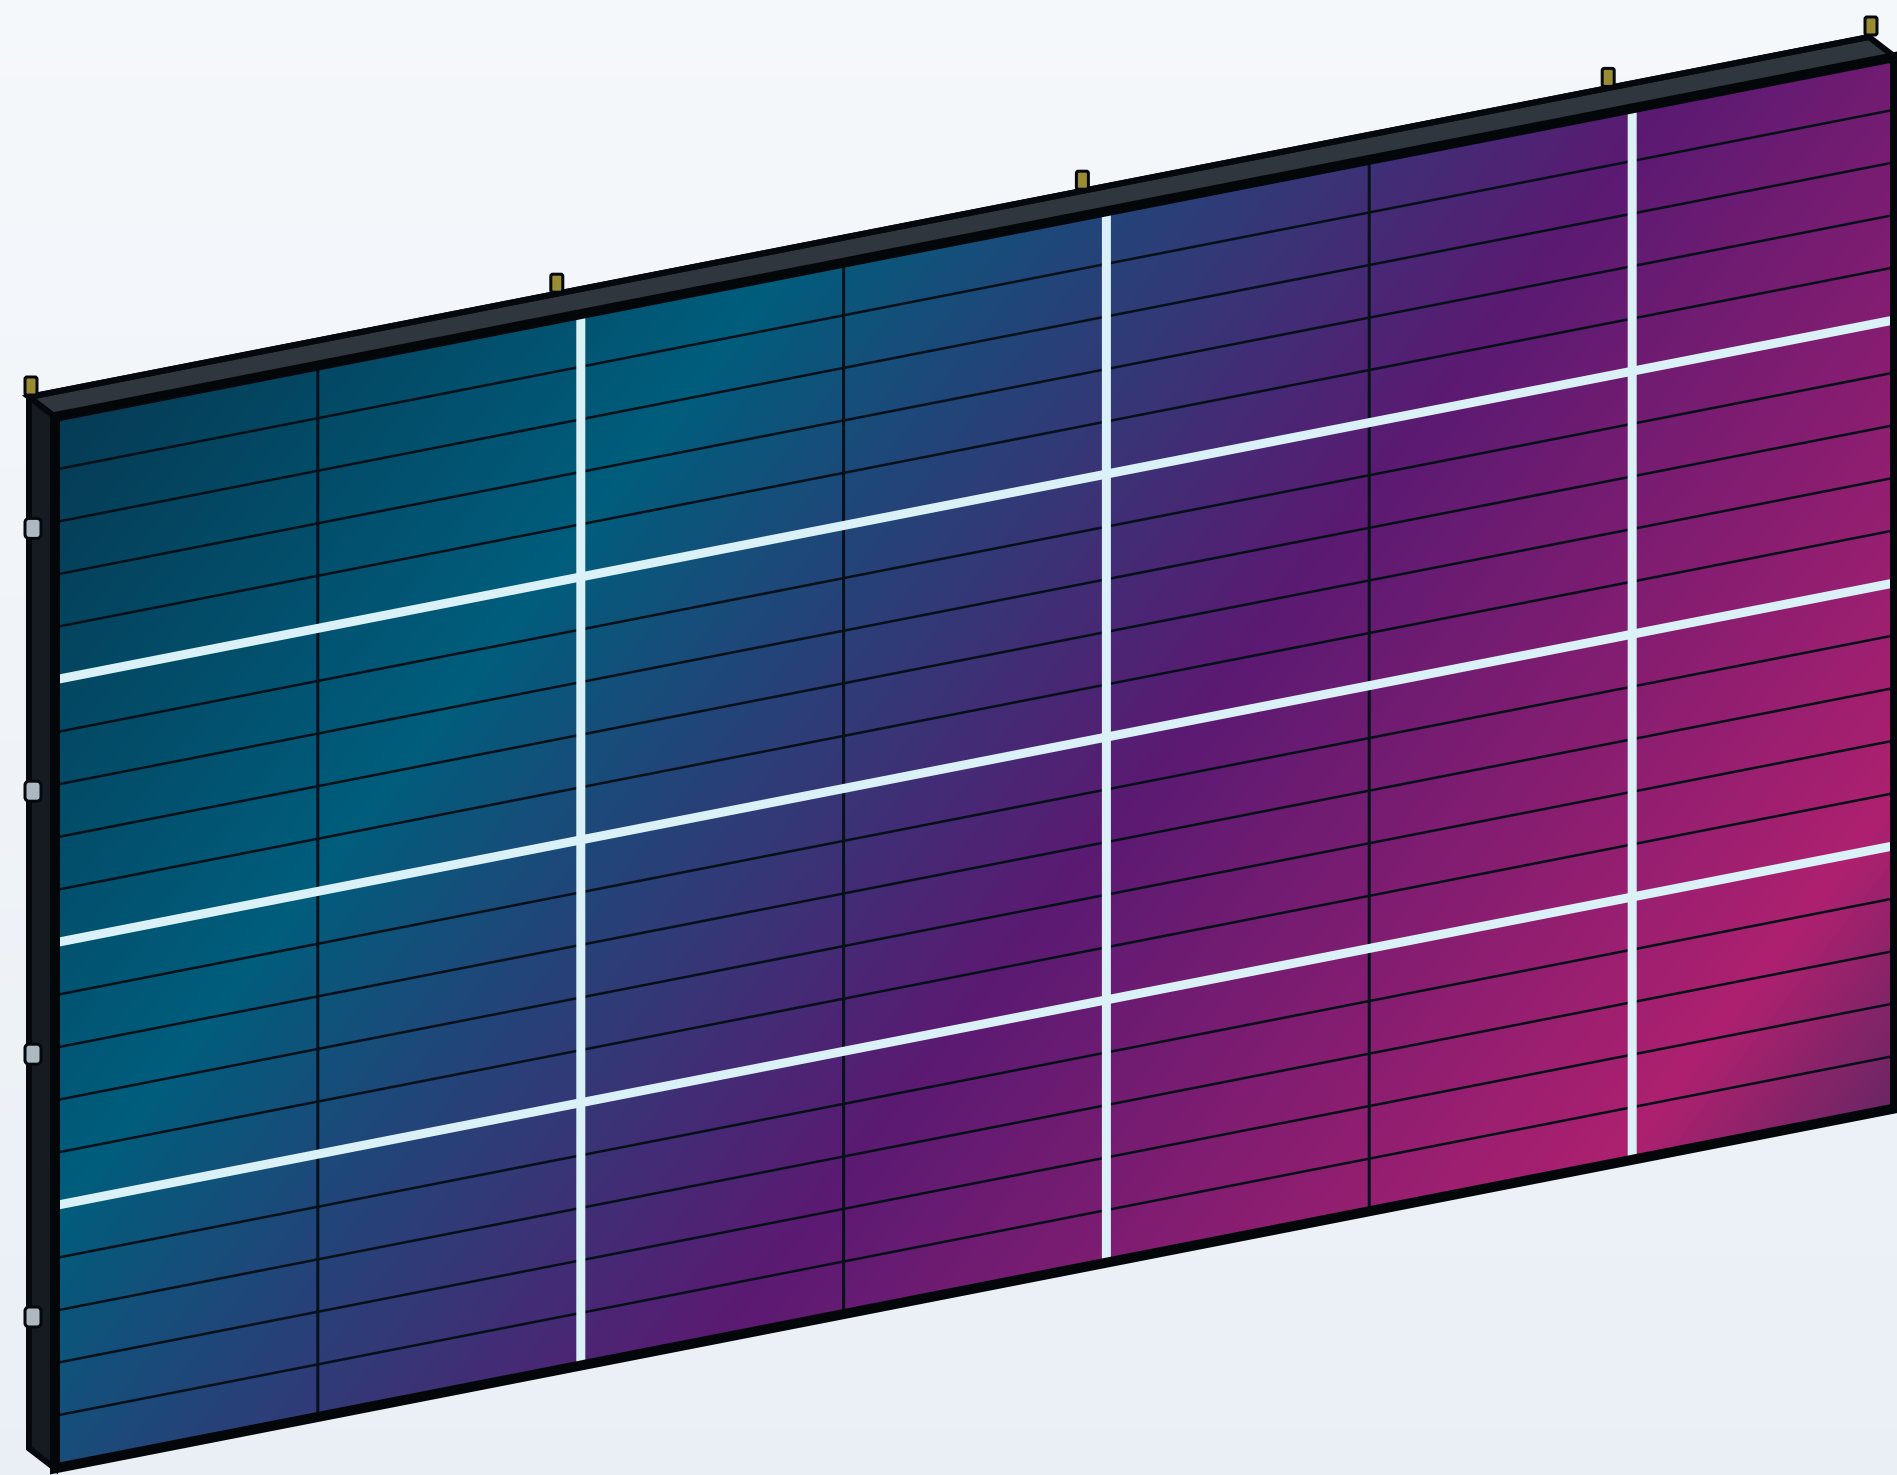


ACTIVE LED FRONT | 1000 x 500 mm CABINET LAYOUT | NTS

SIDE ELEVATION

ACTUAL CABINET PROFILE

OVERALL DEPTH 82 mm / 3.23 in

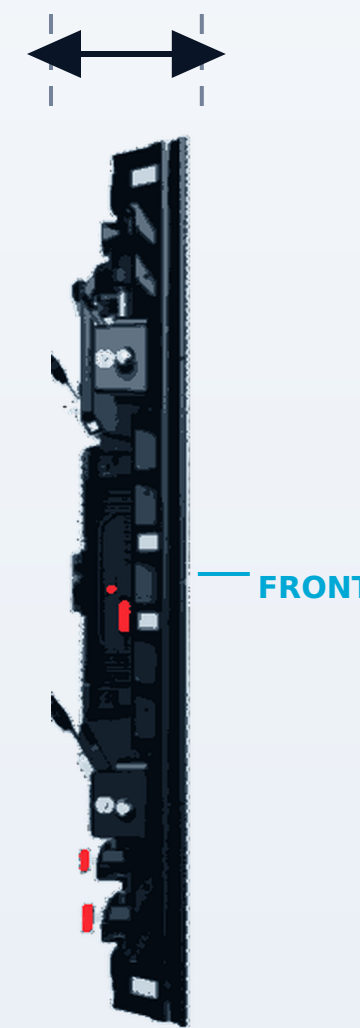

0.082 m / 0.269 ft

PROFILE BASED ON ACTUAL CABINET | NTS

PHYSICAL SIZE

3.5 m W x 2 m H x 82 mm D

IMPERIAL SIZE

11.48 ft W x 6.56 ft H x 3.23 in D

DIAGONAL

158.71 in / 13.23 ft / 4.031 m

PIXEL PITCH

P3.91 mm (3.90625 mm nominal geometry)

NATIVE RESOLUTION

896 x 512 pixels

TOTAL PIXELS

458,752 pixels

DISPLAY AREA

7.00 square metres / 75.35 square feet

CABINET ARRANGEMENT

4 columns x 4 rows

CABINET SCHEDULE

12 x 1000 x 500 mm + 4 x 500 x 500 mm

DRAWING TITLE

PHANTOM P3.91 - 3.5 m x 2 m PACKAGE

DRAWING NO.

PH-3500x2000-GA

SCALE

NTS

REVISION

E

DATE

2026-10-03

DEPTH

82 mm

GENERAL NOTES

Dimensions are nominal. Final rigging, support, power and structural engineering to be confirmed for each installation.