



PHANTOM SERIES


TRANSPARENT OUTDOOR RENTAL LED - TECHNICAL PACKAGE DRAWING

MODEL NUMBER


BLAV-PH-P391-5500X3000

P3.91 | 5.5 m x 3 m | REV E

DIMENSIONED FRONT ELEVATION

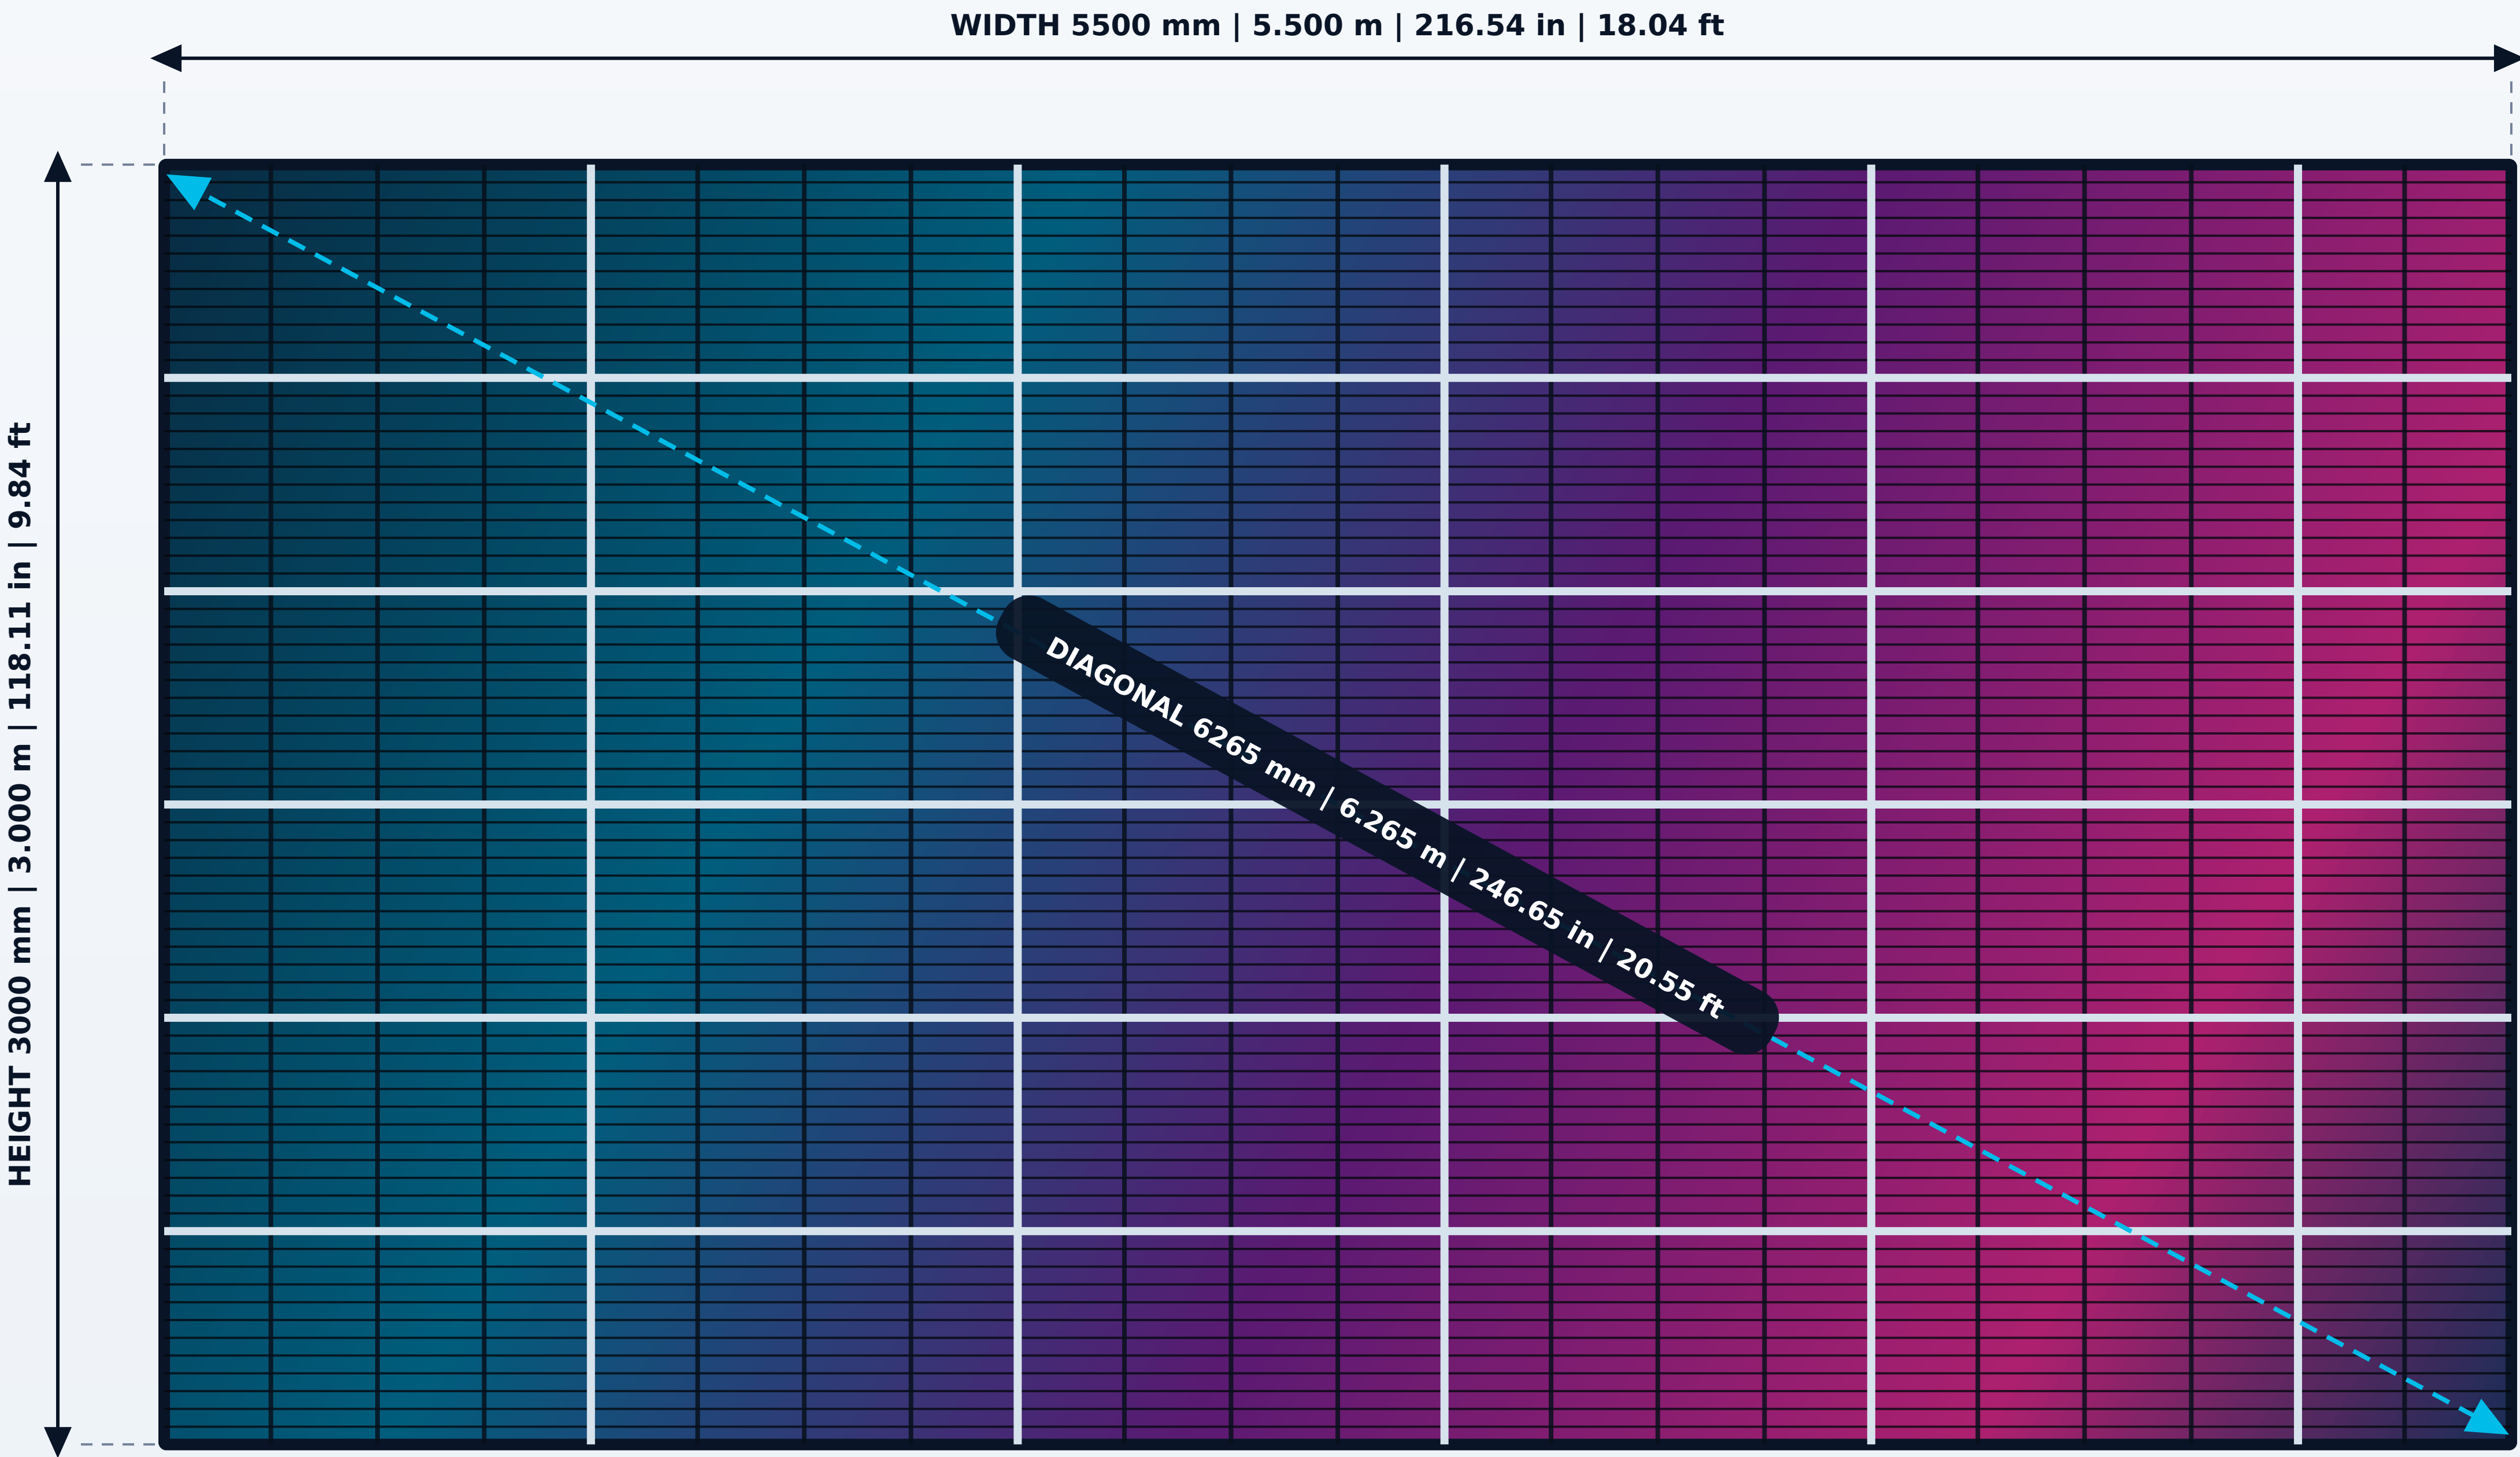


REAR ELEVATION

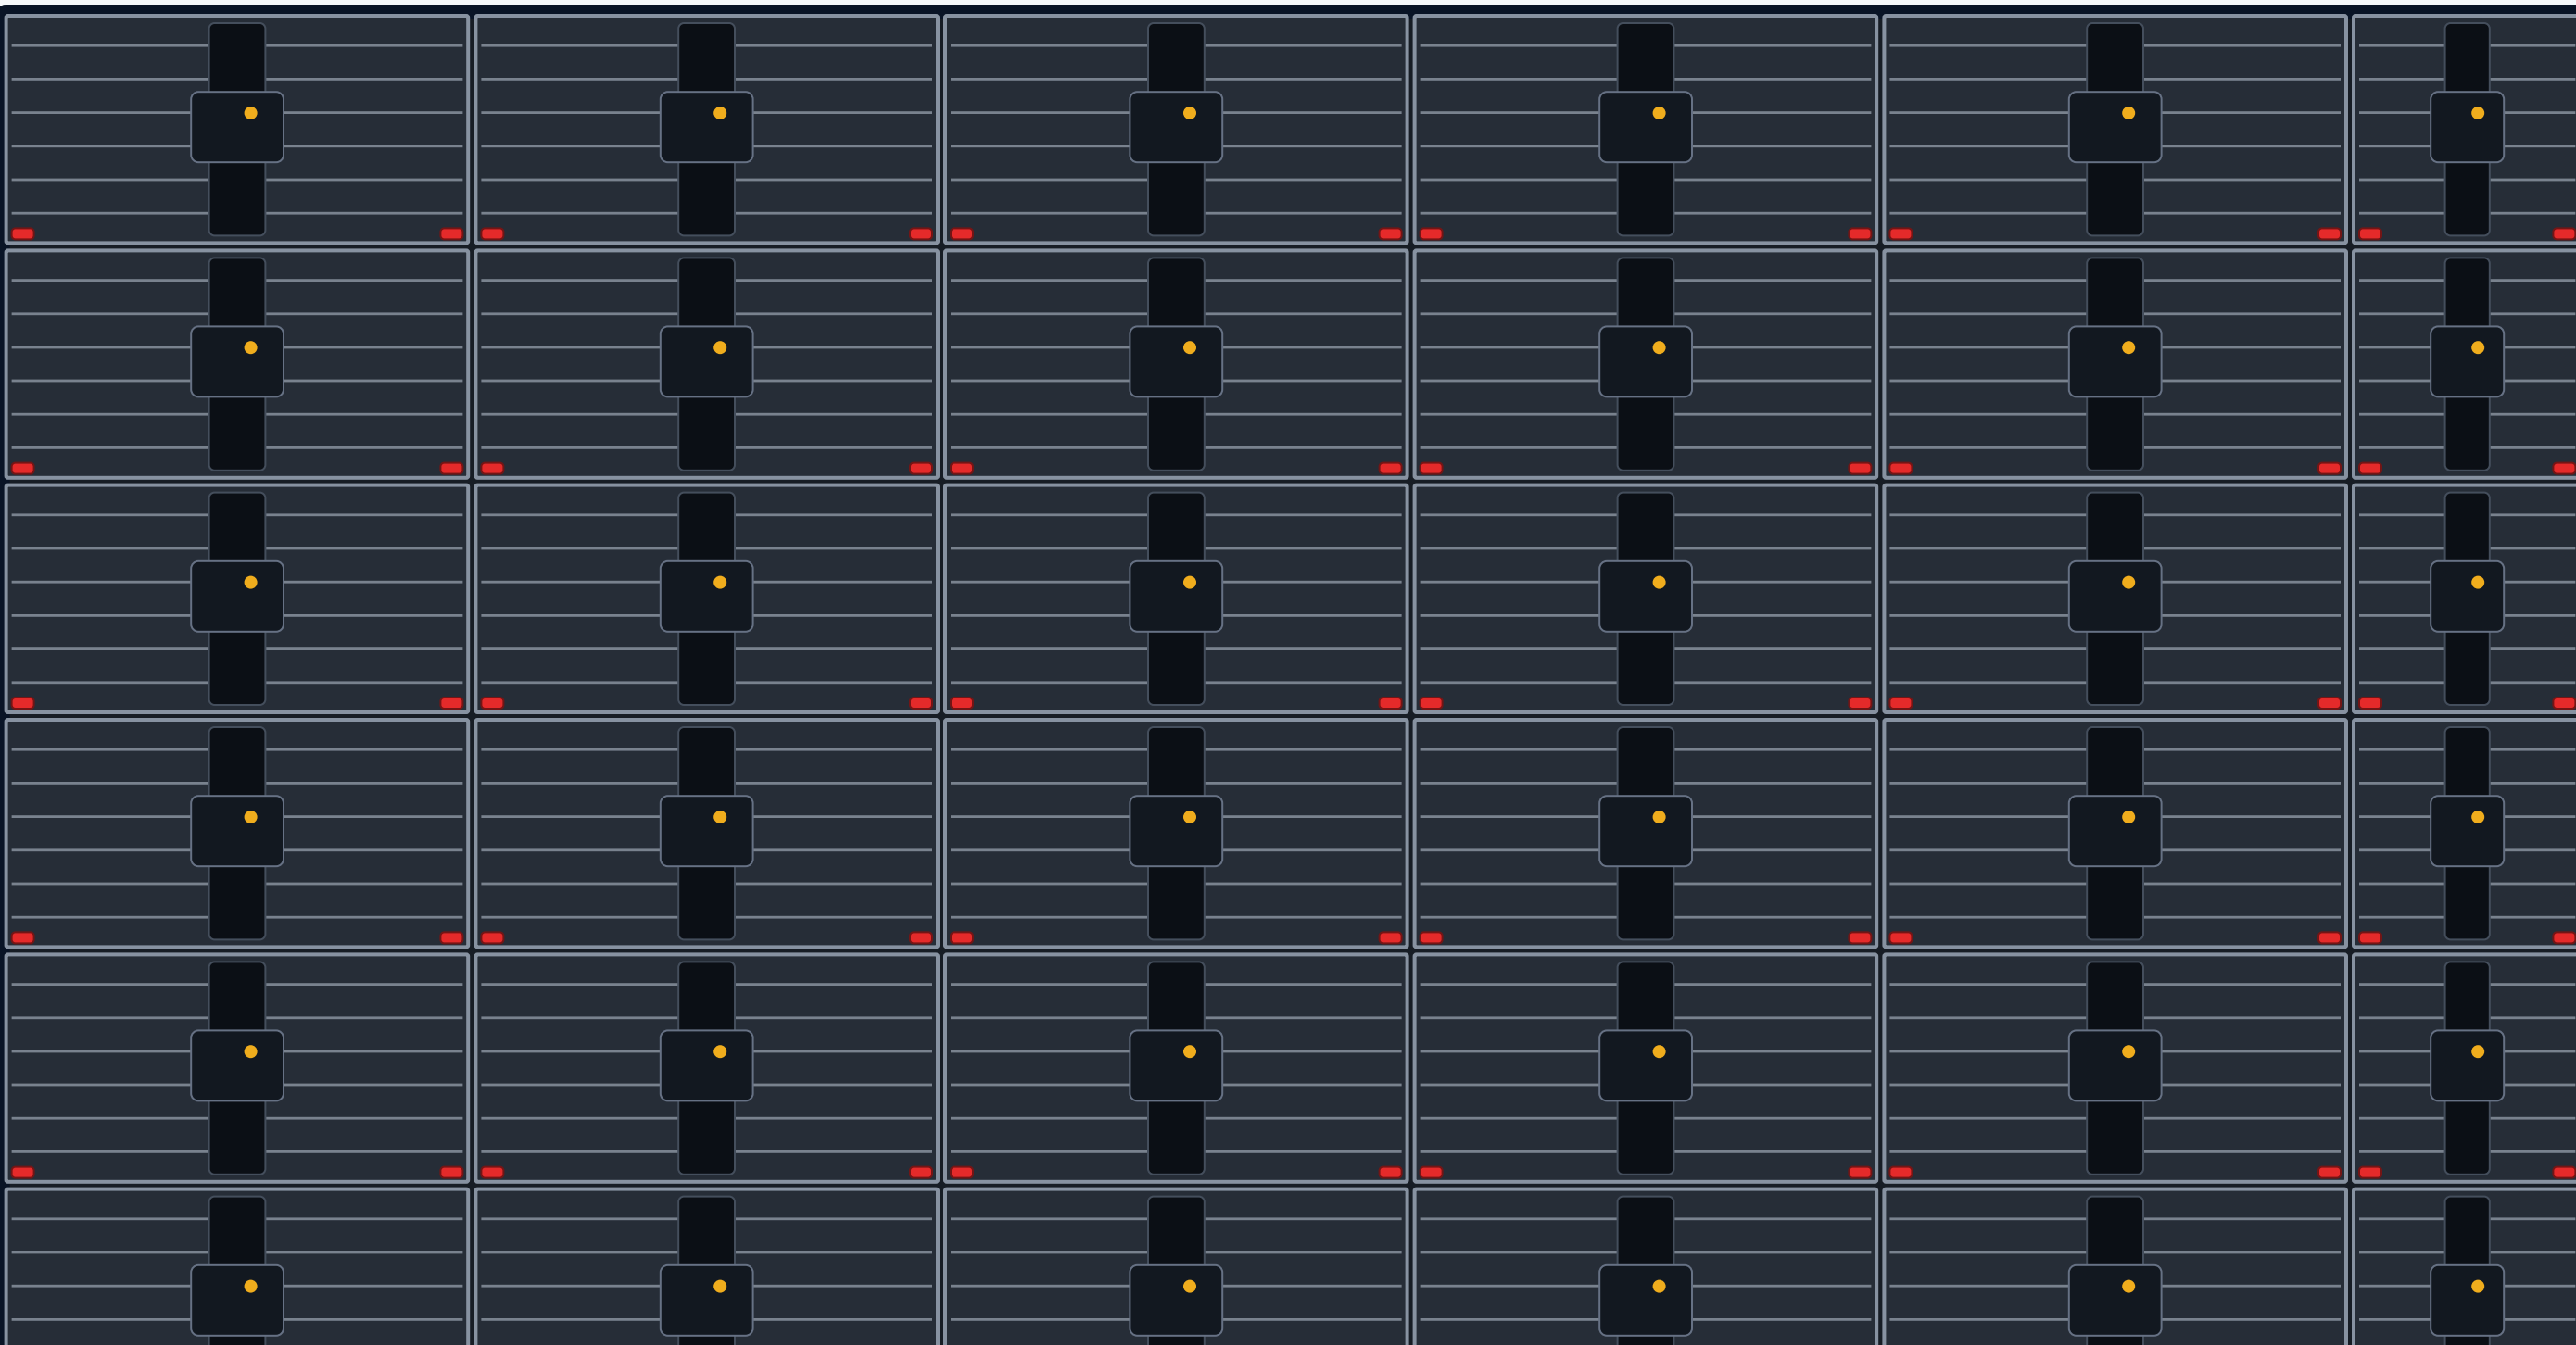

36 PHYSICAL CABINETS

THREE-QUARTER ASSEMBLY VIEW

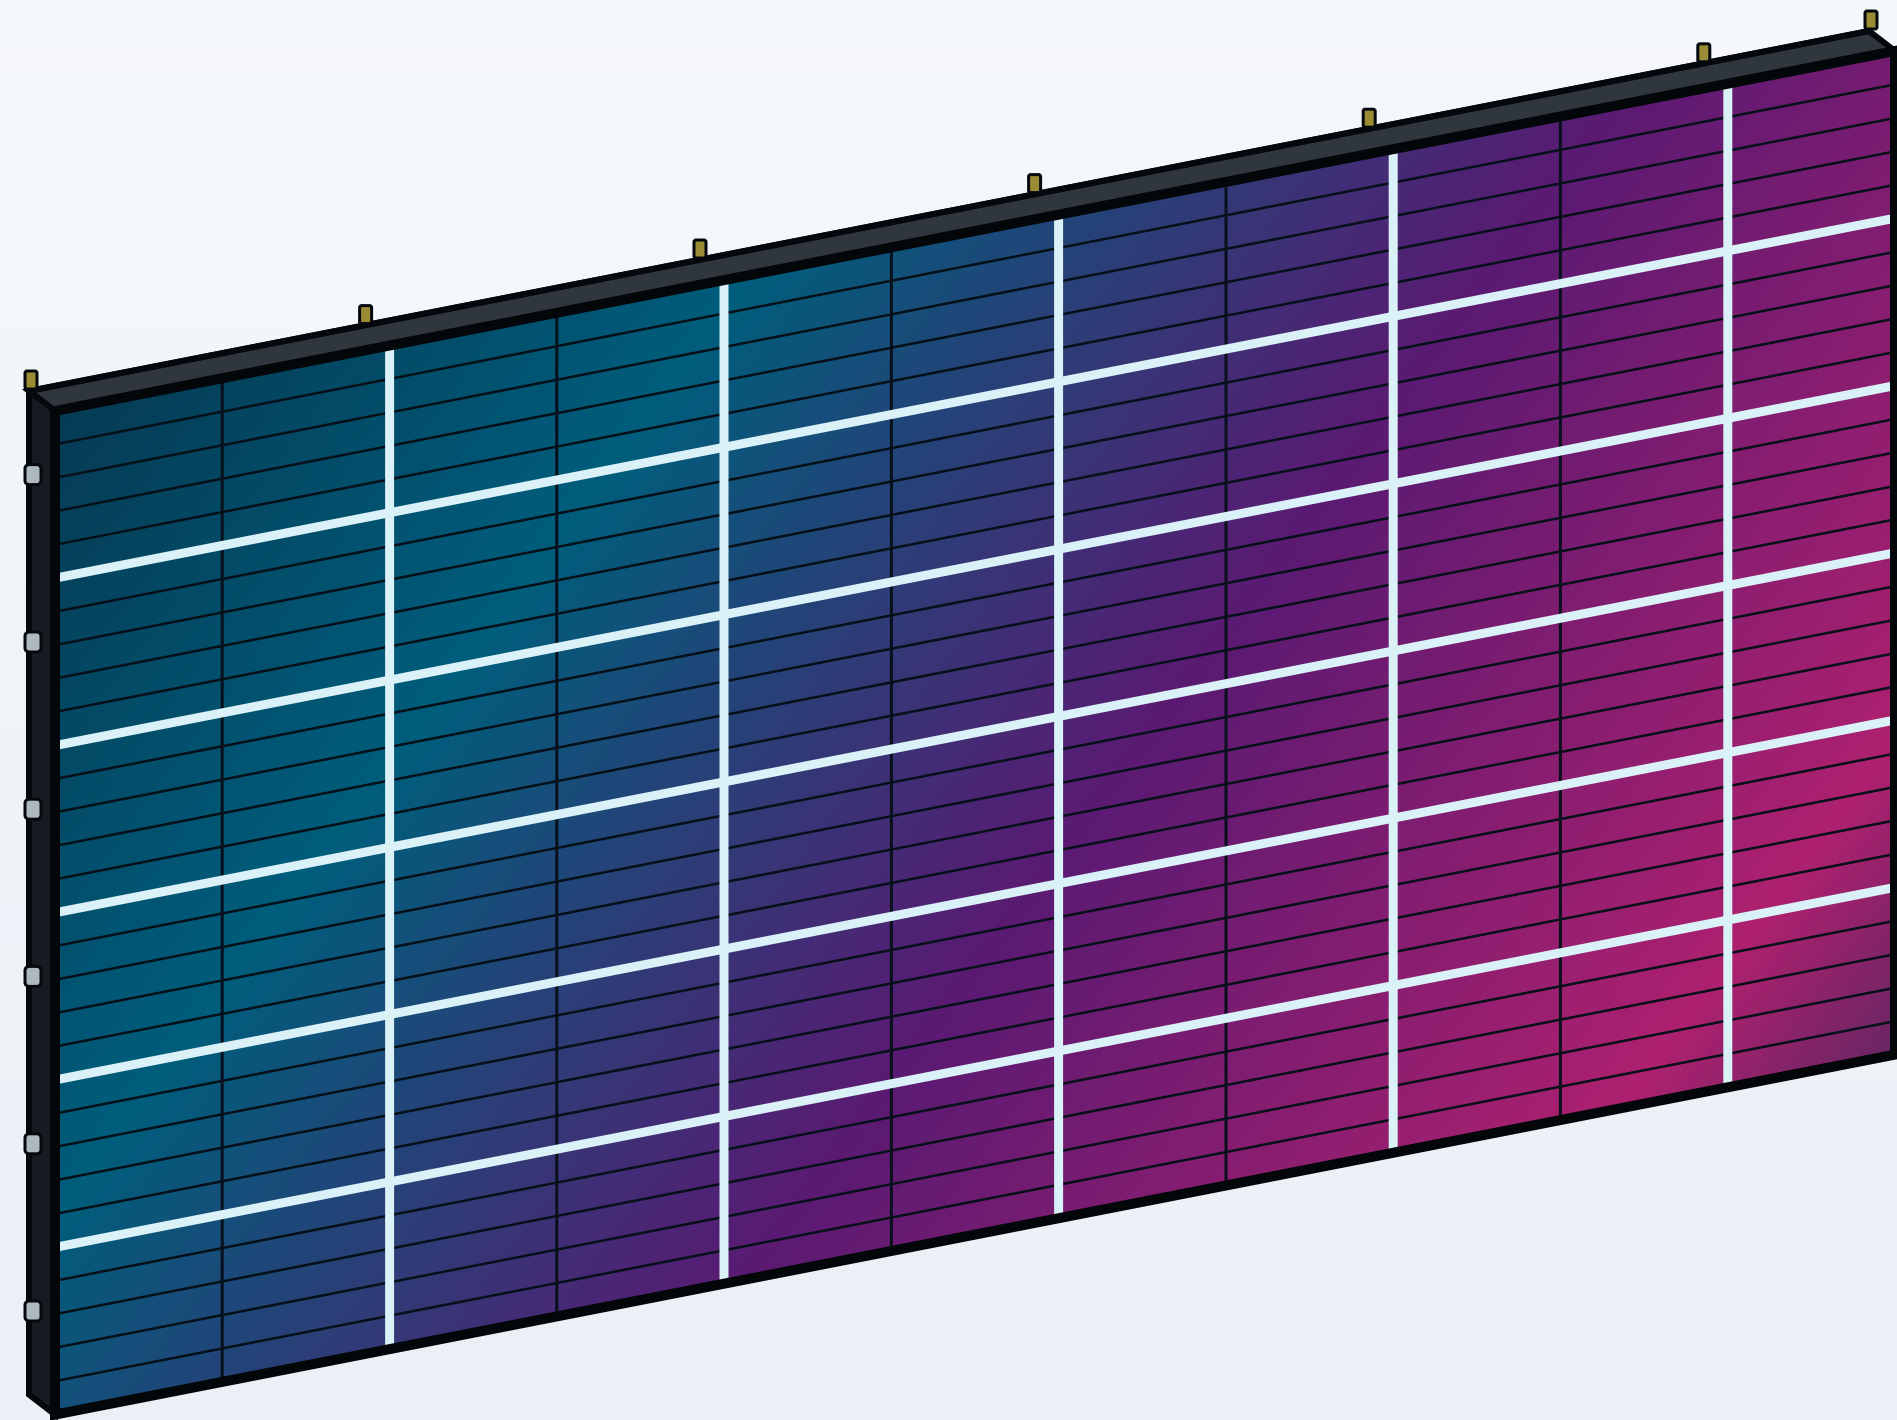


ACTIVE LED FRONT | 1000 x 500 mm CABINET LAYOUT | NTS

SIDE ELEVATION

ACTUAL CABINET PROFILE

OVERALL DEPTH 82 mm / 3.23 in

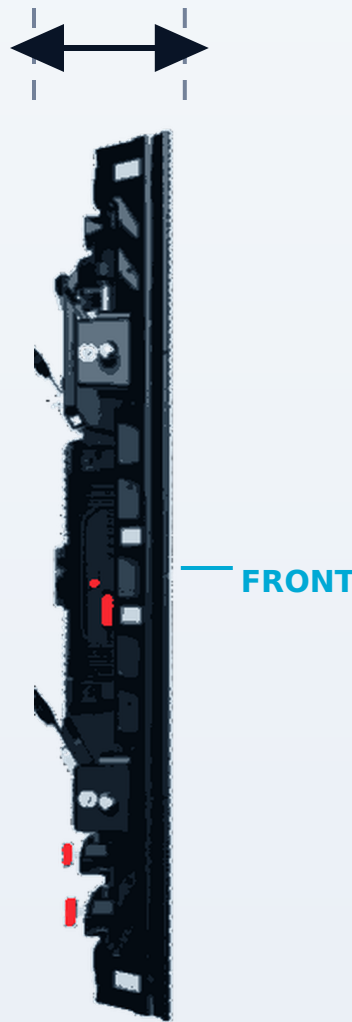

0.082 m / 0.269 ft

PROFILE BASED ON ACTUAL CABINET | NTS

PHYSICAL SIZE

5.5 m W x 3 m H x 82 mm D

IMPERIAL SIZE

18.04 ft W x 9.84 ft H x 3.23 in D

DIAGONAL

246.65 in / 20.55 ft / 6.265 m

PIXEL PITCH

P3.91 mm (3.90625 mm nominal geometry)

NATIVE RESOLUTION

1408 x 768 pixels

TOTAL PIXELS

1,081,344 pixels

DISPLAY AREA

16.50 square metres / 177.60 square feet

CABINET ARRANGEMENT

6 columns x 6 rows

CABINET SCHEDULE

30 x 1000 x 500 mm + 6 x 500 x 500 mm

DRAWING TITLE

PHANTOM P3.91 - 5.5 m x 3 m PACKAGE

DRAWING NO.

PH-5500x3000-GA

SCALE

NTS

REVISION

E

DATE

2026-10-03

DEPTH

82 mm

GENERAL NOTES

Dimensions are nominal. Final rigging, support, power and structural engineering to be confirmed for each installation.