



PHANTOM SERIES


TRANSPARENT OUTDOOR RENTAL LED - TECHNICAL PACKAGE DRAWING

MODEL NUMBER


BLAV-PH-P391-5000X2500

P3.91 | 5 m x 2.5 m | REV E

DIMENSIONED FRONT ELEVATION

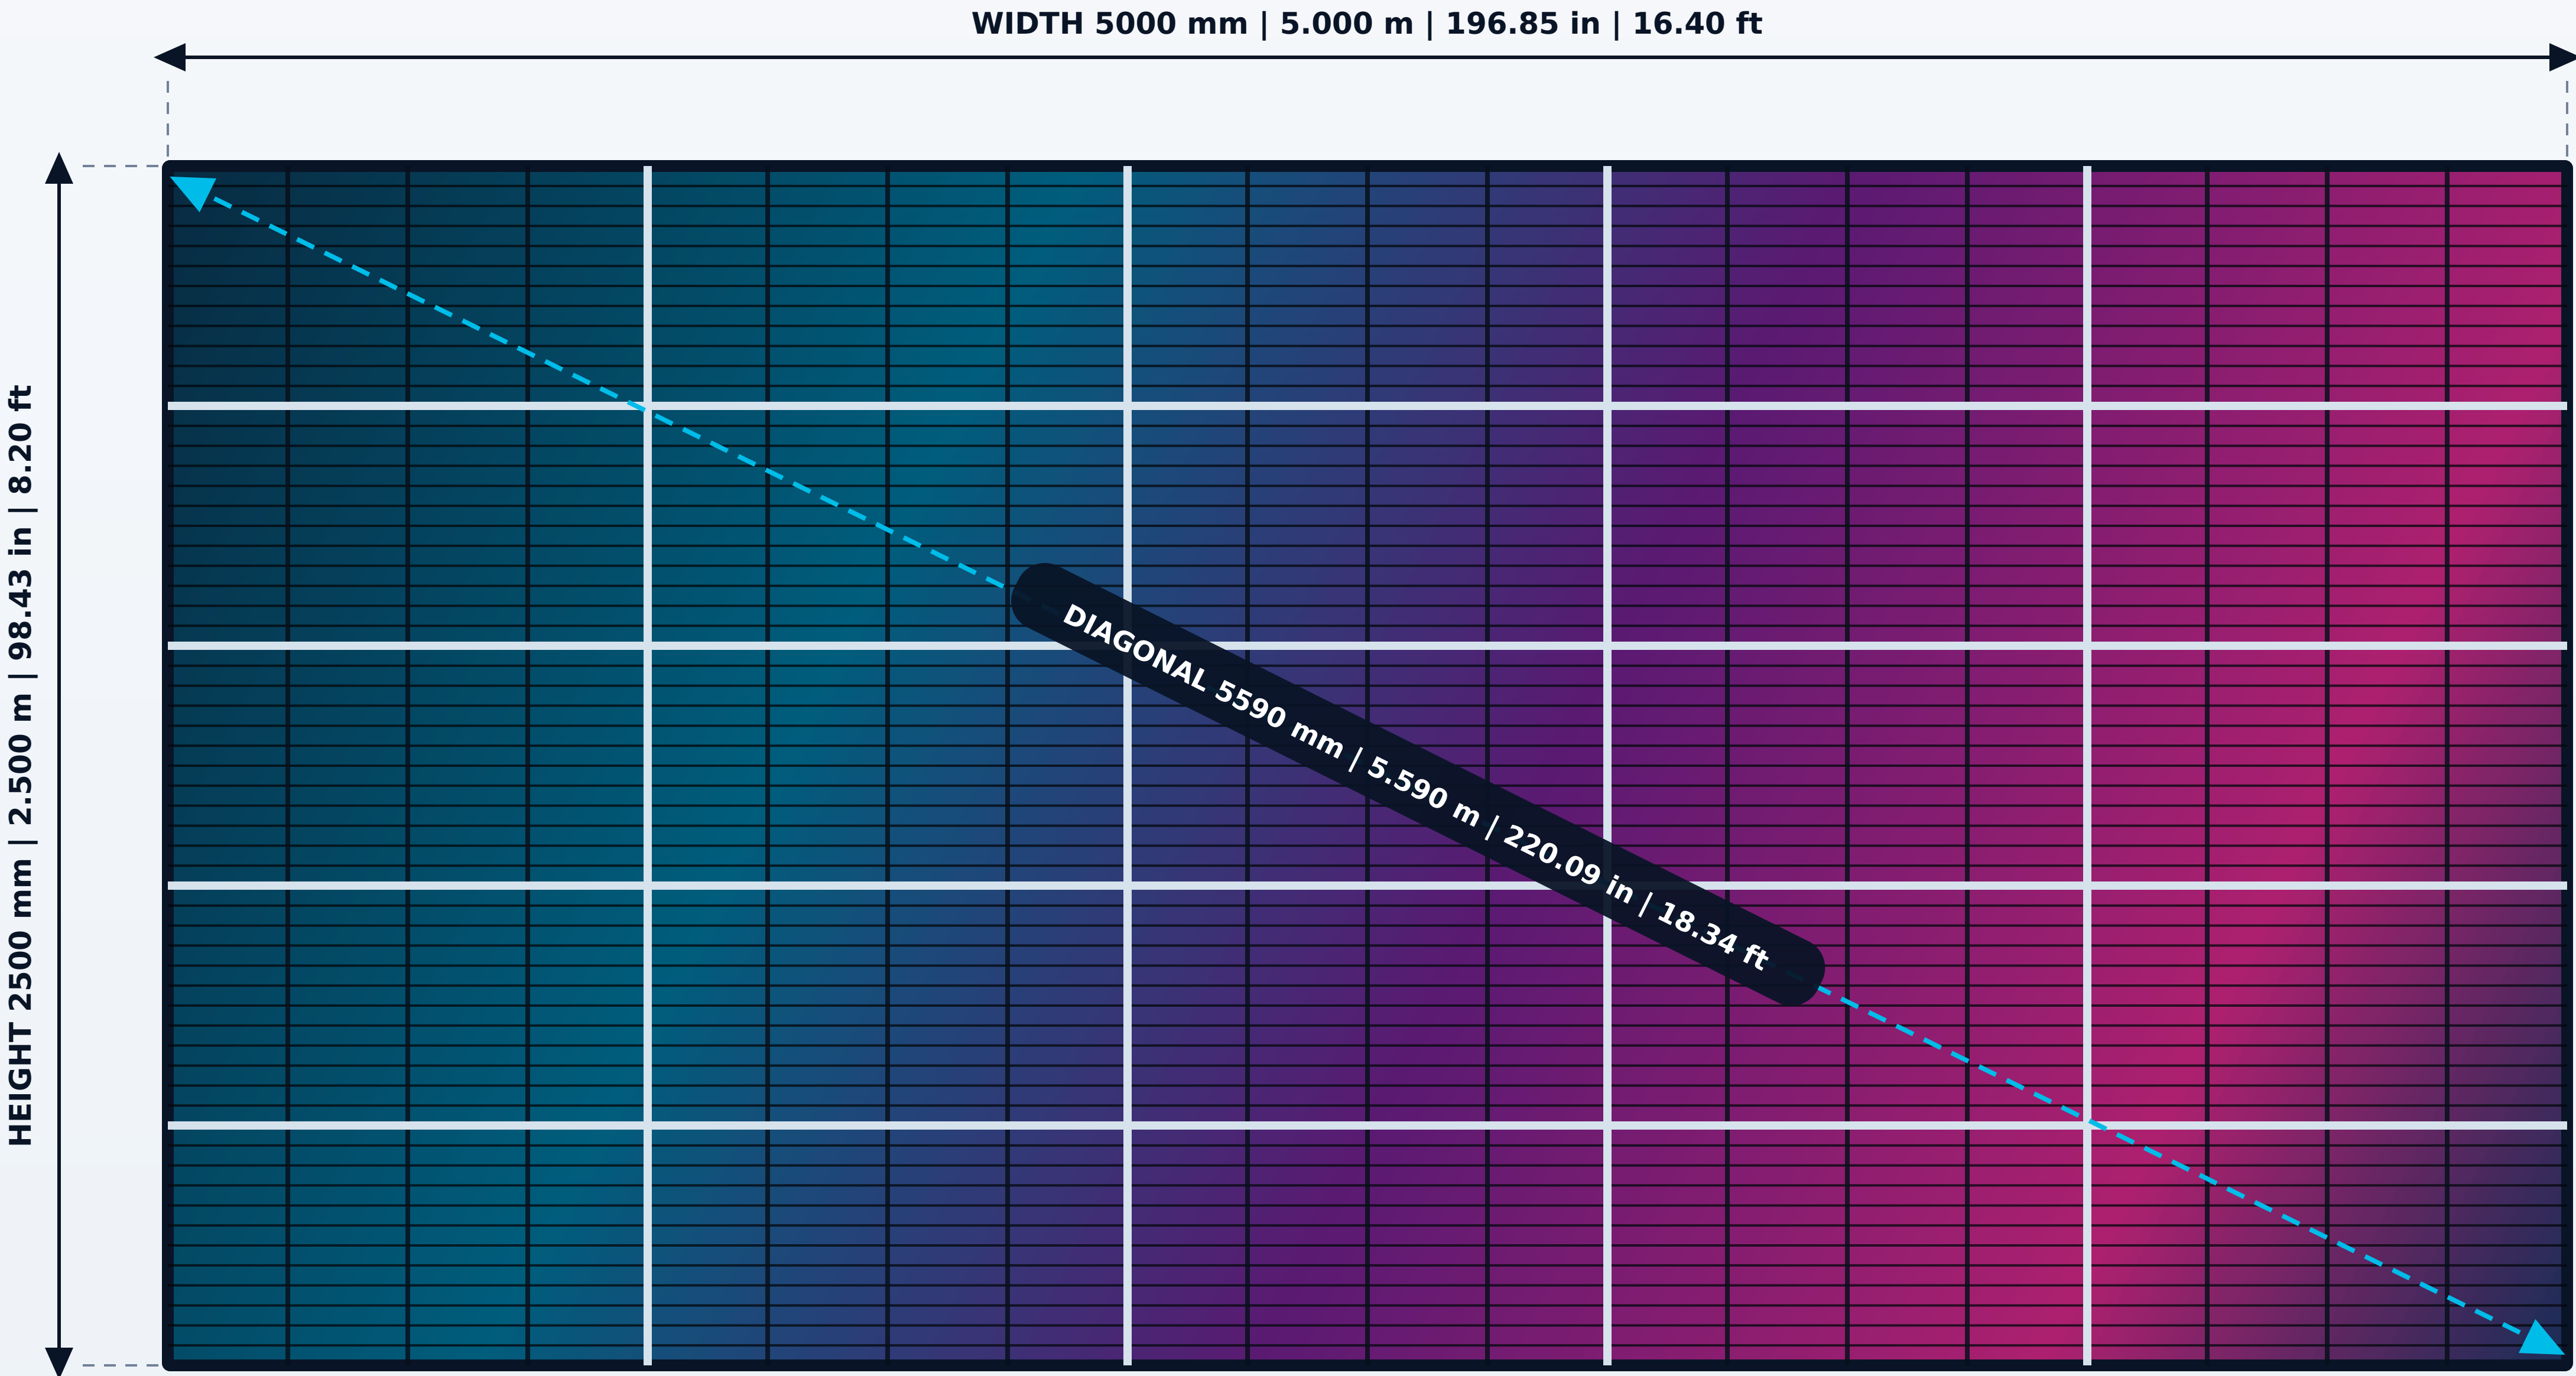


REAR ELEVATION

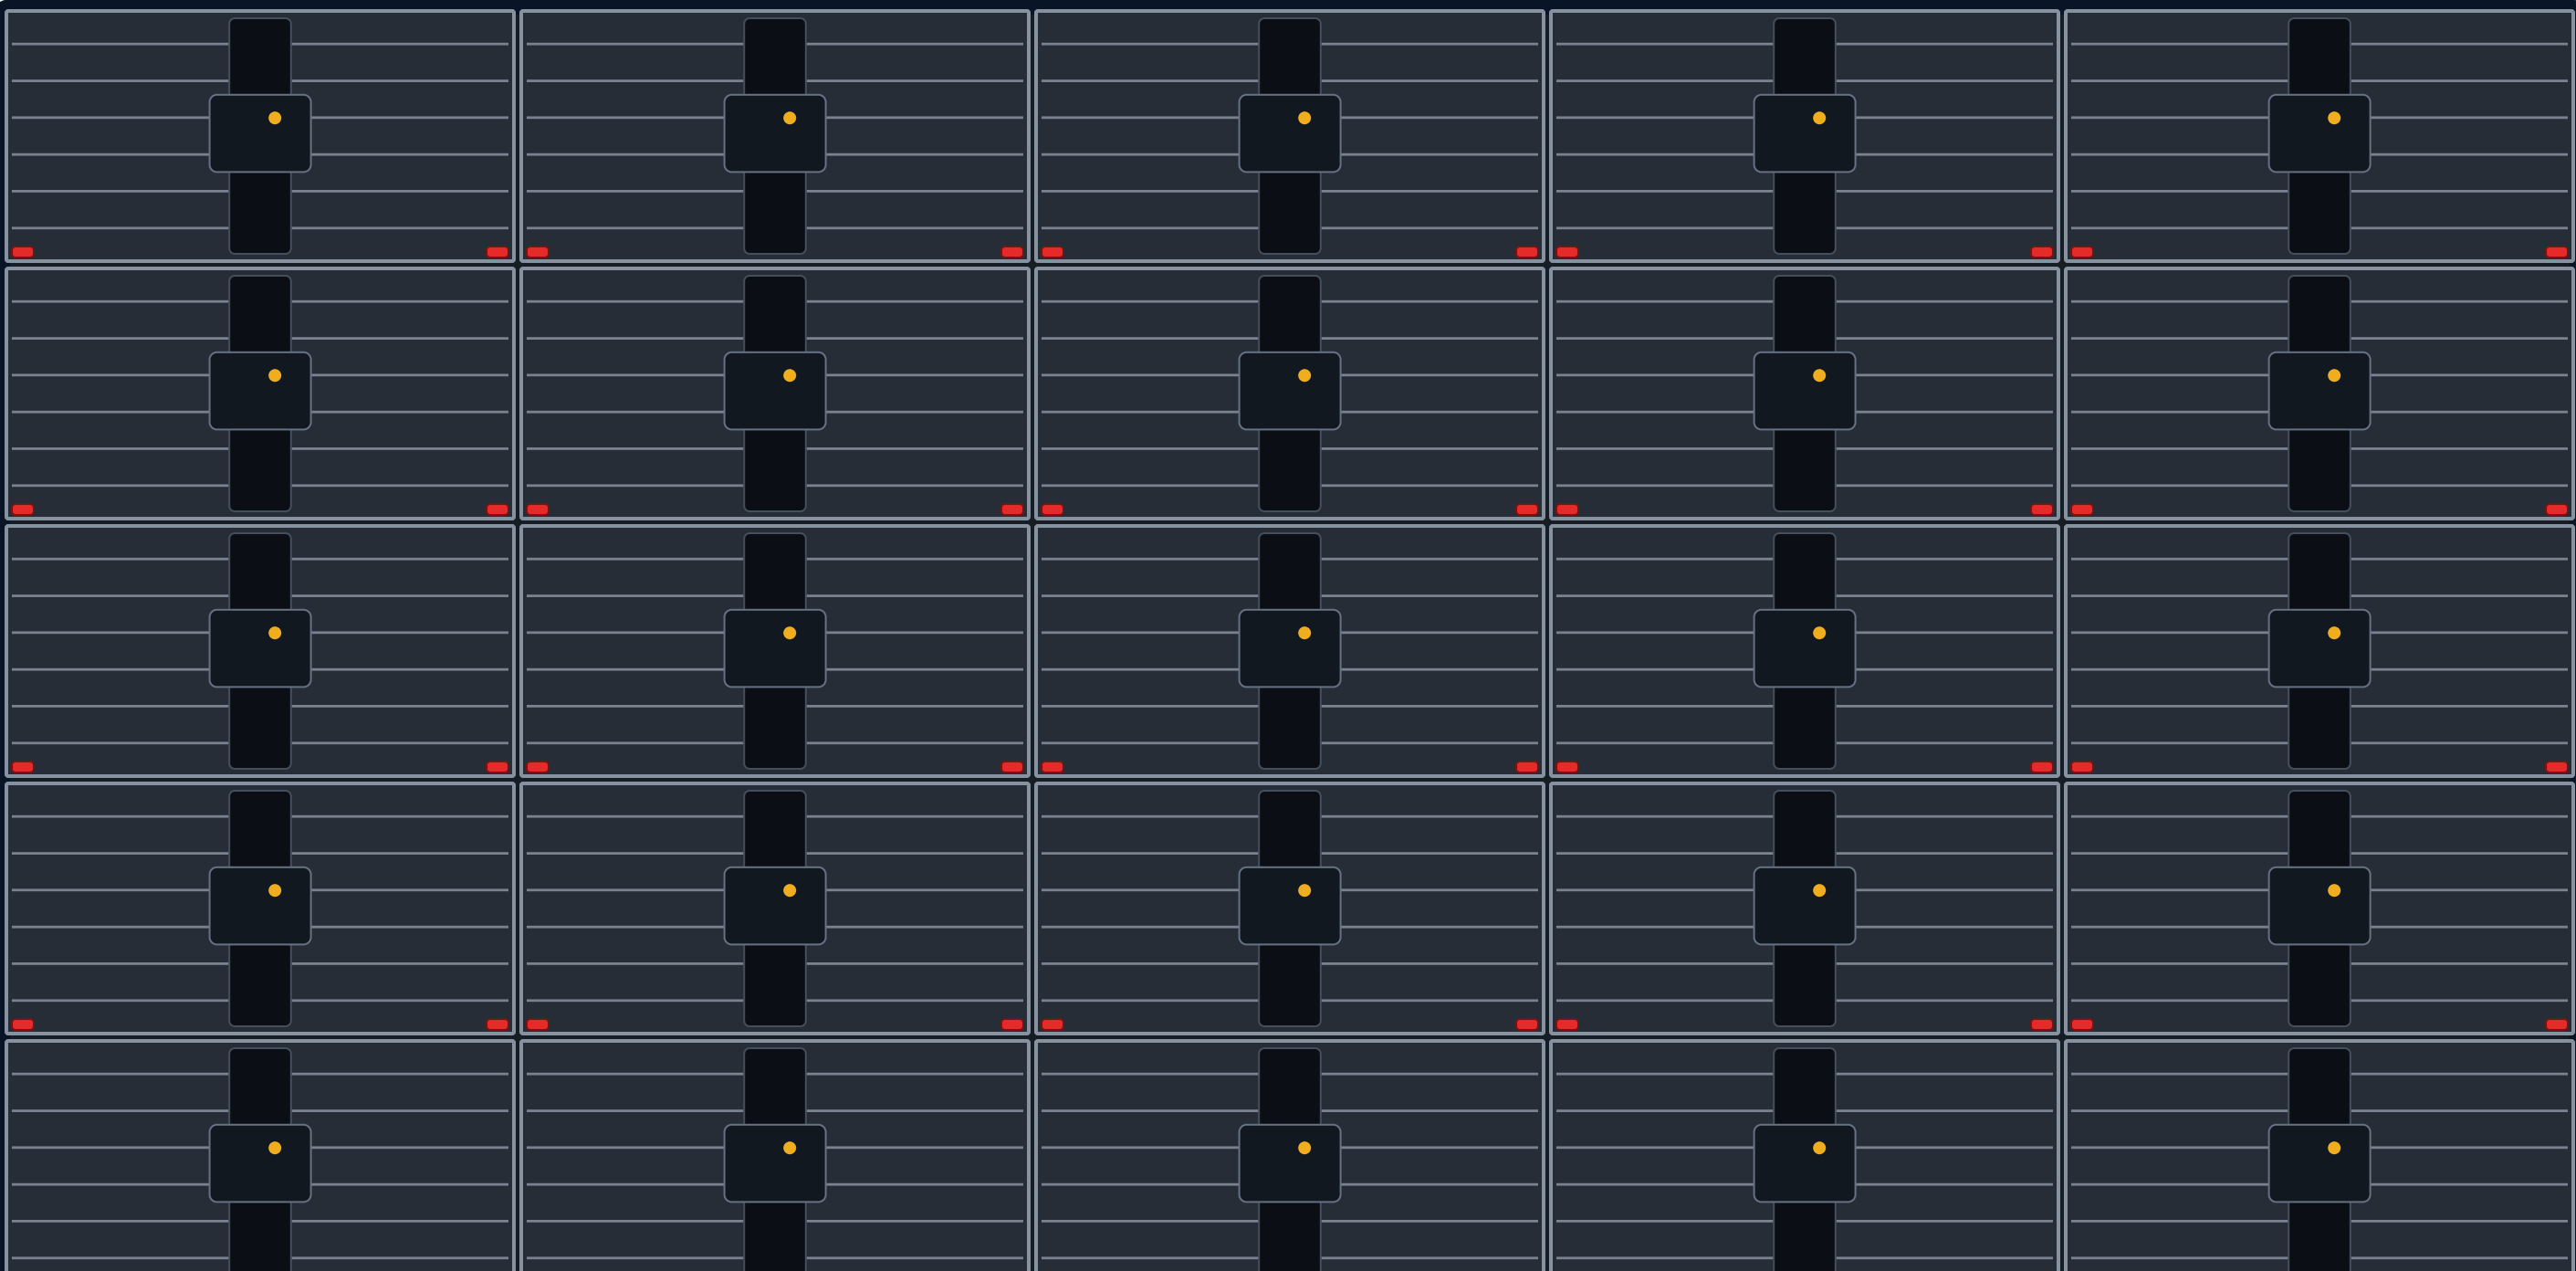

25 PHYSICAL CABINETS

THREE-QUARTER ASSEMBLY VIEW

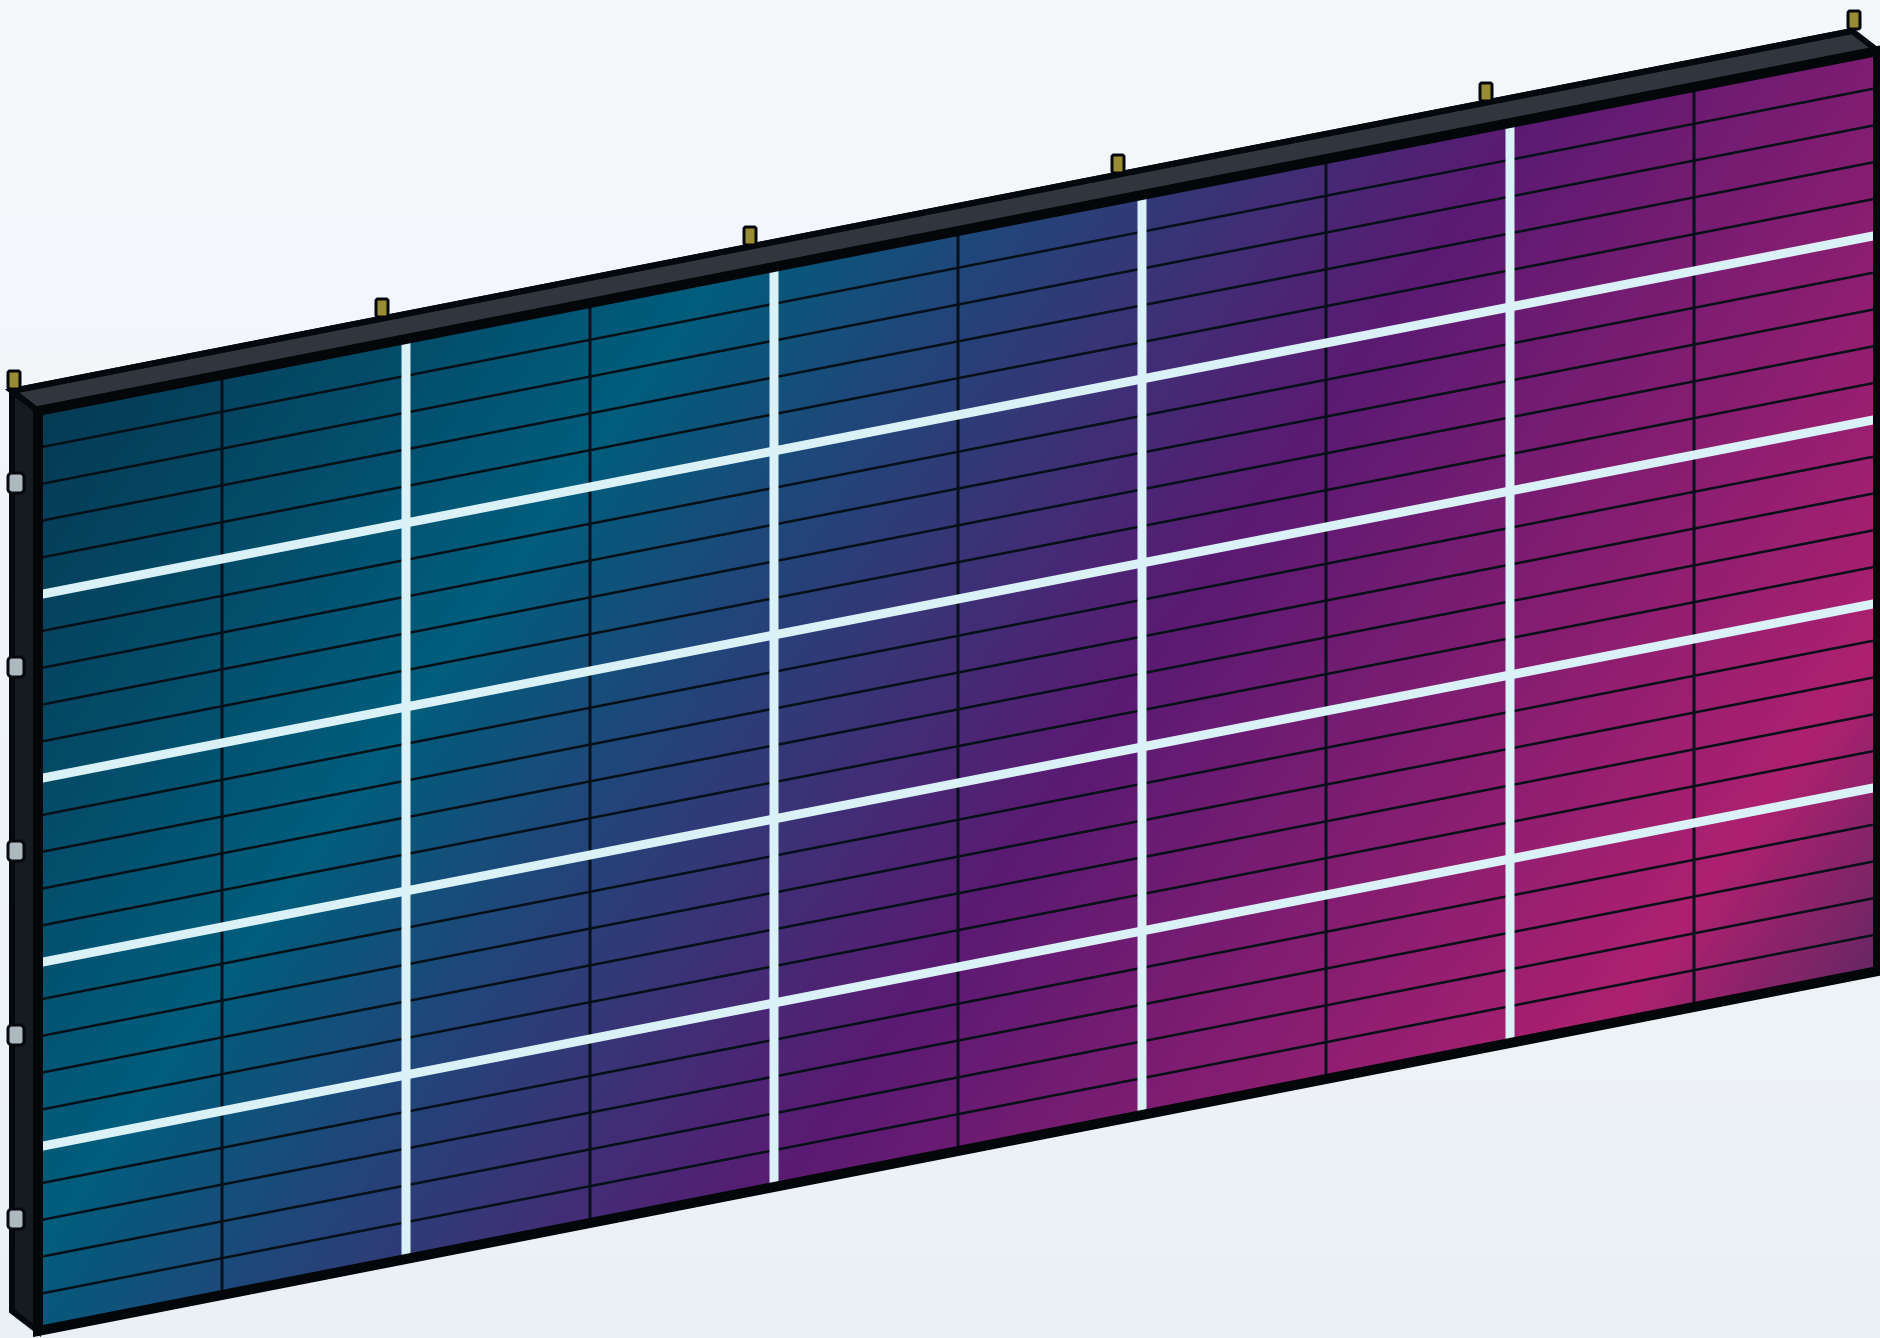


ACTIVE LED FRONT | 1000 x 500 mm CABINET LAYOUT | NTS

SIDE ELEVATION

ACTUAL CABINET PROFILE

OVERALL DEPTH 82 mm / 3.23 in

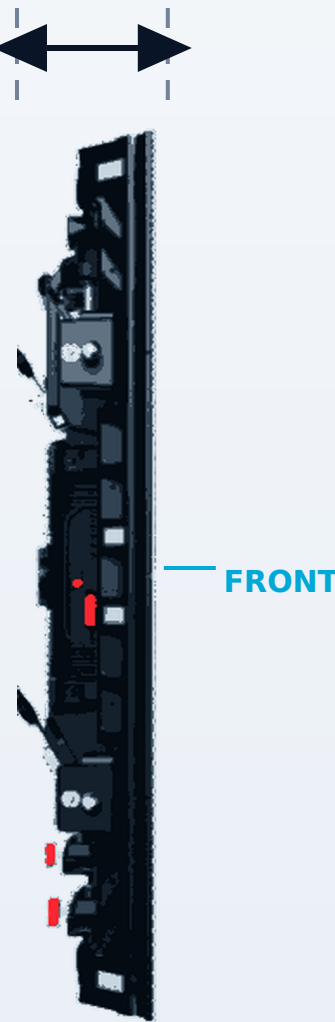

0.082 m / 0.269 ft

PROFILE BASED ON ACTUAL CABINET | NTS

PHYSICAL SIZE

5 m W x 2.5 m H x 82 mm D

IMPERIAL SIZE

16.40 ft W x 8.20 ft H x 3.23 in D

DIAGONAL

220.09 in / 18.34 ft / 5.590 m

PIXEL PITCH

P3.91 mm (3.90625 mm nominal geometry)

NATIVE RESOLUTION

1280 x 640 pixels

TOTAL PIXELS

819,200 pixels

DISPLAY AREA

12.50 square metres / 134.55 square feet

CABINET ARRANGEMENT

5 columns x 5 rows

CABINET SCHEDULE

25 x 1000 x 500 mm

DRAWING TITLE

PHANTOM P3.91 - 5 m x 2.5 m PACKAGE

DRAWING NO.

PH-5000x2500-GA

SCALE

NTS

REVISION

E

DATE

2026-10-03

DEPTH

82 mm

GENERAL NOTES

Dimensions are nominal. Final rigging, support, power and structural engineering to be confirmed for each installation.